




New York City Department of Environmental Protection
North River Wastewater Treatment Plant:
Cogeneration and Electrification Project
LIMITED PROJECT ENGINEERING DRAWINGS (*DRAFTS*)

Michael R. Bloomberg
Mayor

Carter H. Strickland, Jr.
Commissioner



HUNDSON RIVER

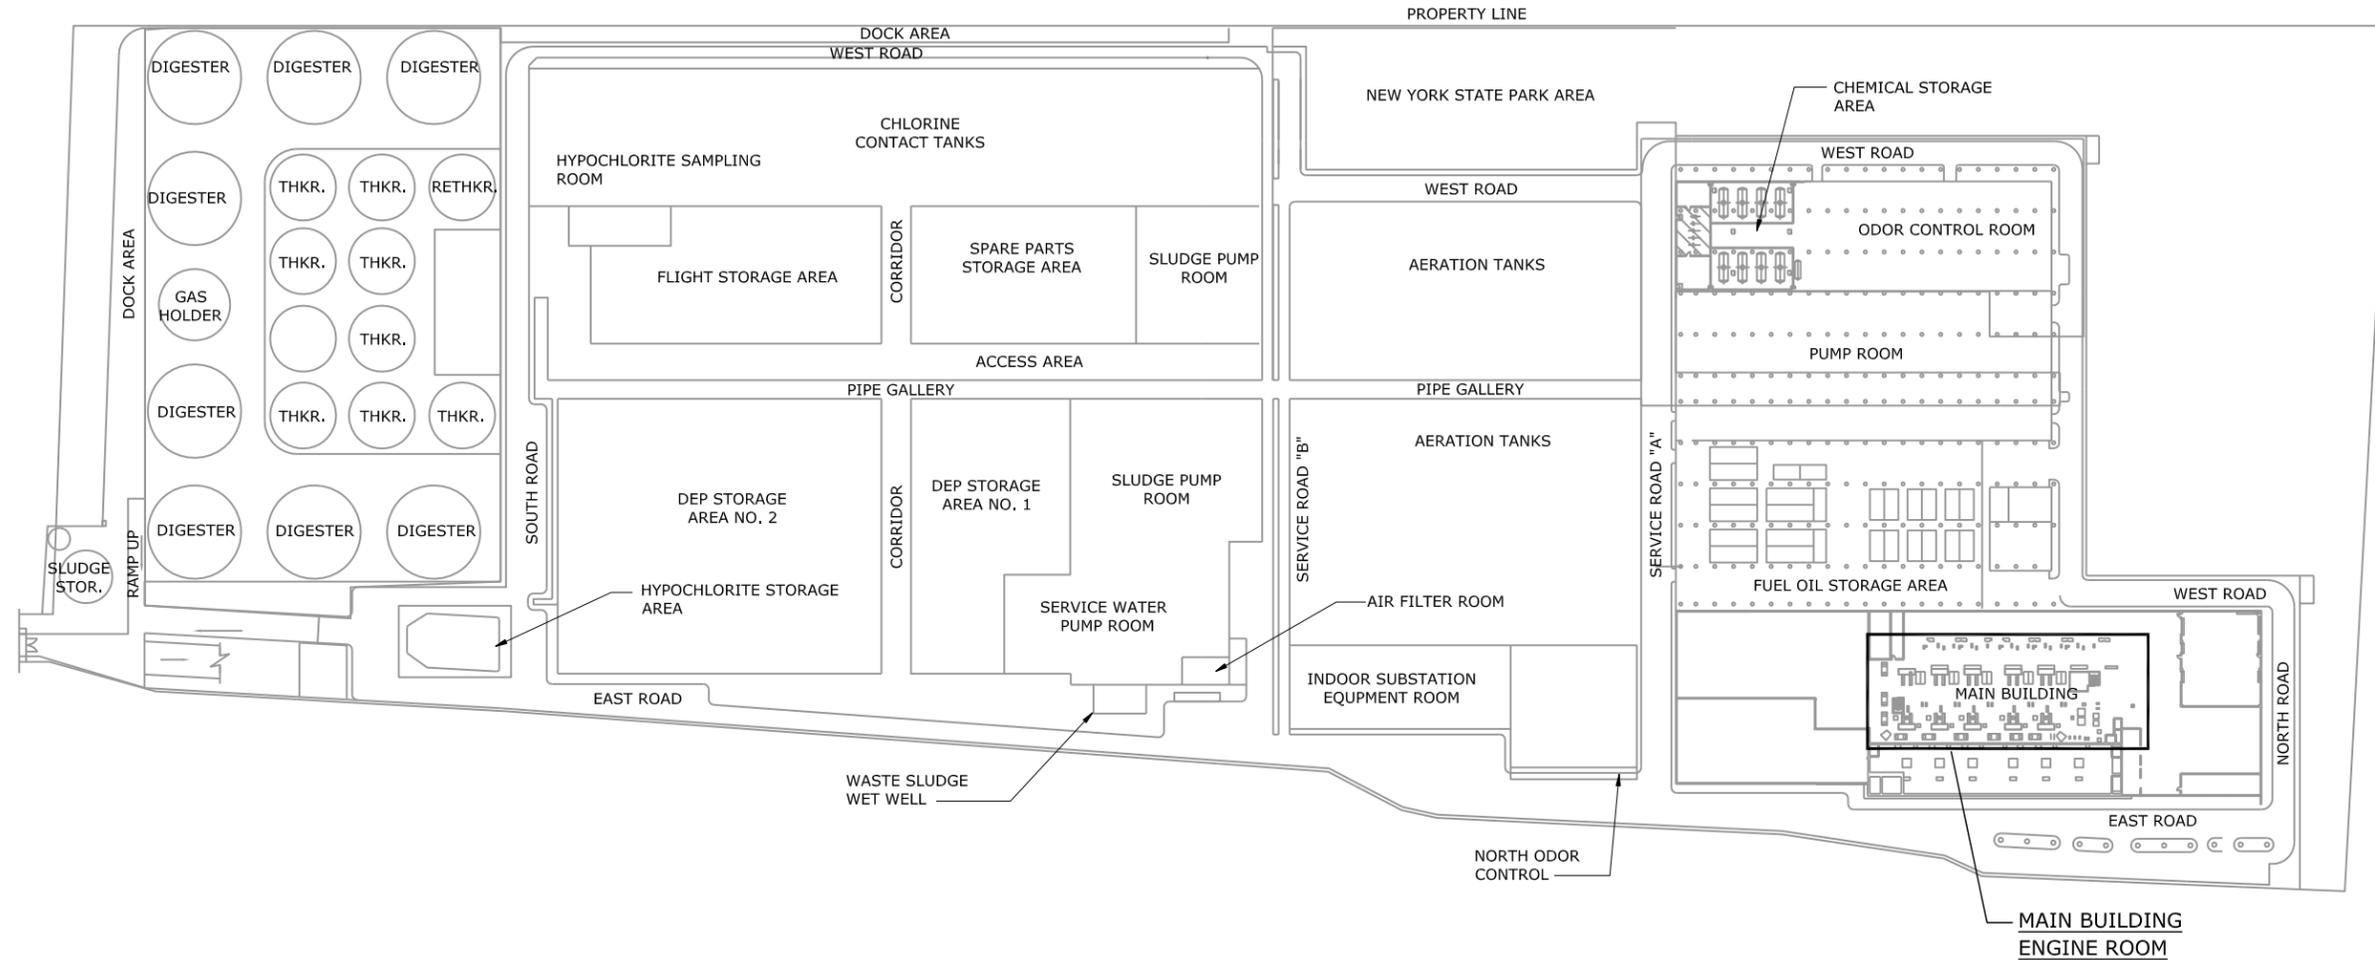

LOCATION PLAN
NO SCALE

GRAPHIC SCALES
CHECK BEFORE USE

IF SHEET IS LESS THAN 22" X 34"
IT IS A REDUCED PRINT.
SCALE ACCORDINGLY

FD174911 BORDER
 Last Save By Date and Time: tj40961\9/9/2012 5:36 PM\Plotstyle Table: dep-bedc - 11x17 reduced drawings.ctb
 Date Plotted: 3/26/2013 11:00 AM\Author: tj40961\File Location: c:\users\mar17242\documents_bim+ projects\north river cogen (177129)\mike j figures\c11-102.dwg

NO.	DATE	DESCRIPTION	APPR'D.
A	09/12	30% DESIGN SUBMITTAL	
REVISIONS			

DESIGNED BY:
MSJ


CHECKED BY:

DESIGN LEAD:

SECTION CHIEF:

DRAWN BY:
DKB

MSJM
BLACK & VEATCH
Building a world of difference

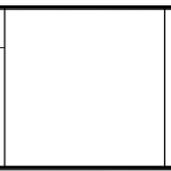

ACCOUNTABLE MANAGER
FRANK GIARDINA

PORTFOLIO MANAGER
JAMES LAURIA

ASST. COMMISSIONER
KEVIN DONNELLY

WARNING—IT IS A VIOLATION, OF THE NEW YORK STATE EDUCATION LAW, SECTION, 7209.2, FOR ANY PERSON, UNLESS (S)HE IS ACTING UNDER THE DIRECTION OF A LICENSED PROFESSIONAL ENGINEER, TO ALTER THIS DOCUMENT IN ANY WAY. IF ALTERED, THE ALTERING PERSON SHALL COMPLY WITH THE REQUIREMENTS OF NEW YORK EDUCATION, LAW, SECTION, 7209.2.

NEW YORK CITY
ENVIRONMENTAL PROTECTION
BUREAU OF ENGINEERING DESIGN & CONSTRUCTION


NORTH RIVER WWTTP
ELECTRIFICATION & COGENERATION
CONTRACT NR-COGEN

DATE: 08/31/12


SCALE: NO SCALE

SHEET NO:
OF

DRAWING NO.
C11-102

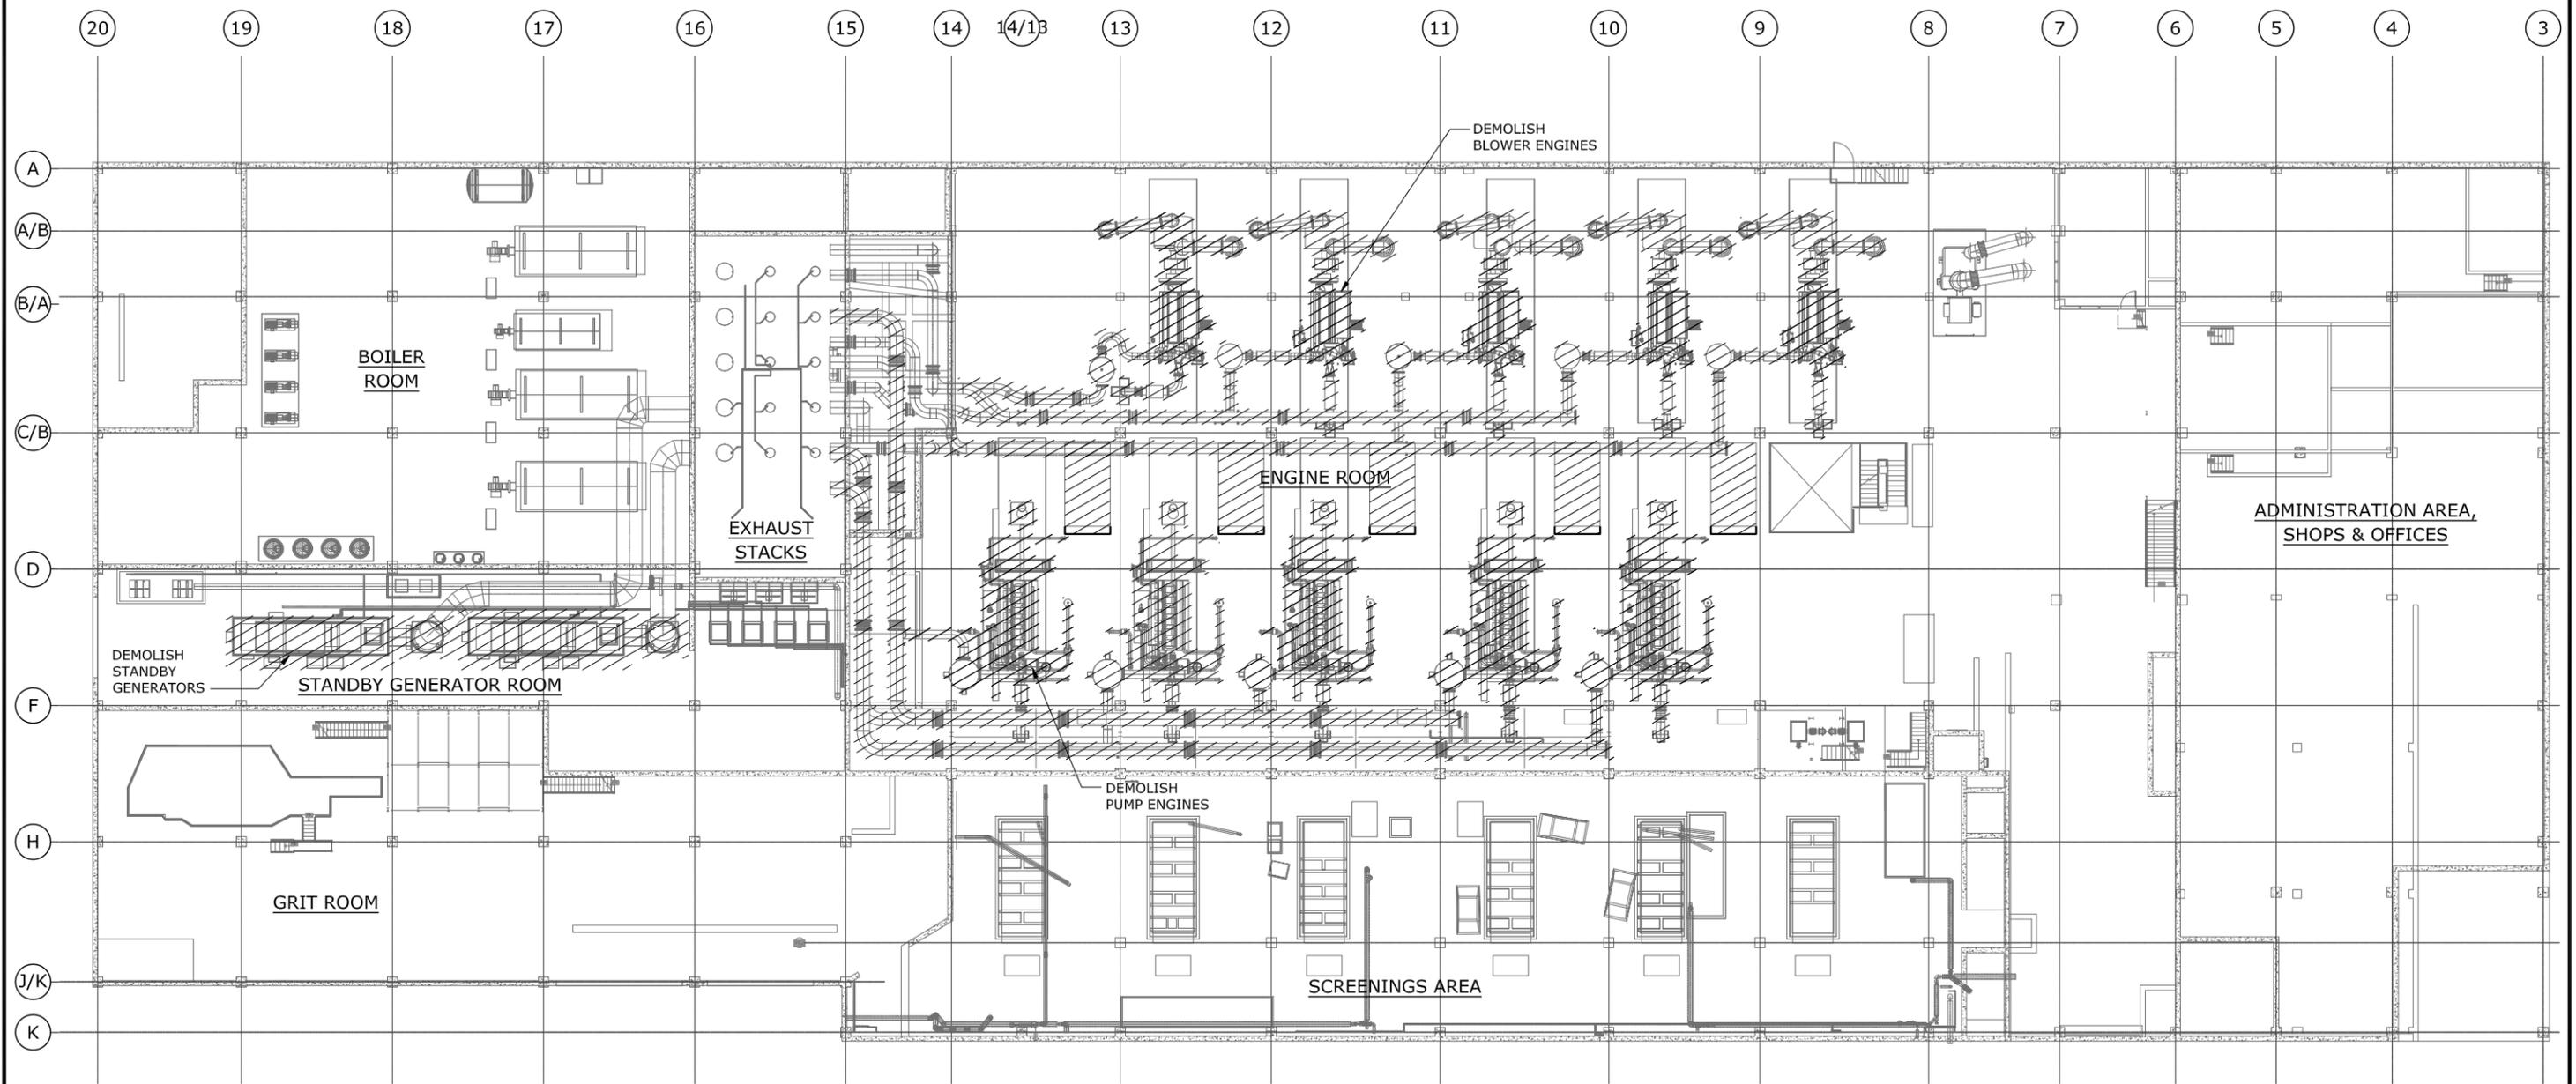

 MAIN BUILDING DEMOLITION PLAN - LEVEL +28.00
 1/16" = 1'-0"



GRAPHIC SCALES
 CHECK BEFORE USE
 IF SHEET IS LESS THAN 22" X 34"
 IT IS A REDUCED PRINT.
 SCALE ACCORDINGLY

FD174911 BORDER
 Last Save By Date and Time: mar17242\3/26/2013 2:26 PM Plotstyle Table: dep-bedc - 11x17 reduced drawings.ctb
 Date Plotted: 3/27/2013 1:34 PM Author: mar17242\file Location: c:\users\mar17242\documents_bim+ projects\north river cogen (177129)\mike.j.figures\m21-800.dwg

NO.	DATE	DESCRIPTION	APPR'D.
A	09/12	30% DESIGN SUBMITTAL	
REVISIONS			

DESIGNED BY:
 CHECKED BY:
 DESIGN LEAD:
 SECTION CHIEF:

DRAWN BY:




ACCOUNTABLE MANAGER
 FRANK GIARDINA
 PORTFOLIO MANAGER
 JAMES LAURIA
 ASST. COMMISSIONER
 KEVIN DONNELLY

WARNING—IT IS A VIOLATION, OF THE NEW YORK STATE EDUCATION LAW, SECTION, 7209.2, FOR ANY PERSON, UNLESS (S)HE IS ACTING UNDER THE DIRECTION OF A LICENSED PROFESSIONAL ENGINEER, TO ALTER THIS DOCUMENT IN ANY WAY. IF ALTERED, THE ALTERING PERSON SHALL COMPLY WITH THE REQUIREMENTS OF NEW YORK EDUCATION, LAW, SECTION, 7209.2.


NEW YORK CITY
ENVIRONMENTAL PROTECTION
 BUREAU OF ENGINEERING DESIGN & CONSTRUCTION

NORTH RIVER WWTP
ELECTRIFICATION & COGENERATION
 CONTRACT NR-COGEN

DATE:
 SCALE: AS SHOWN
 SHEET NO:
 OF
 DRAWING NO.
M21-800

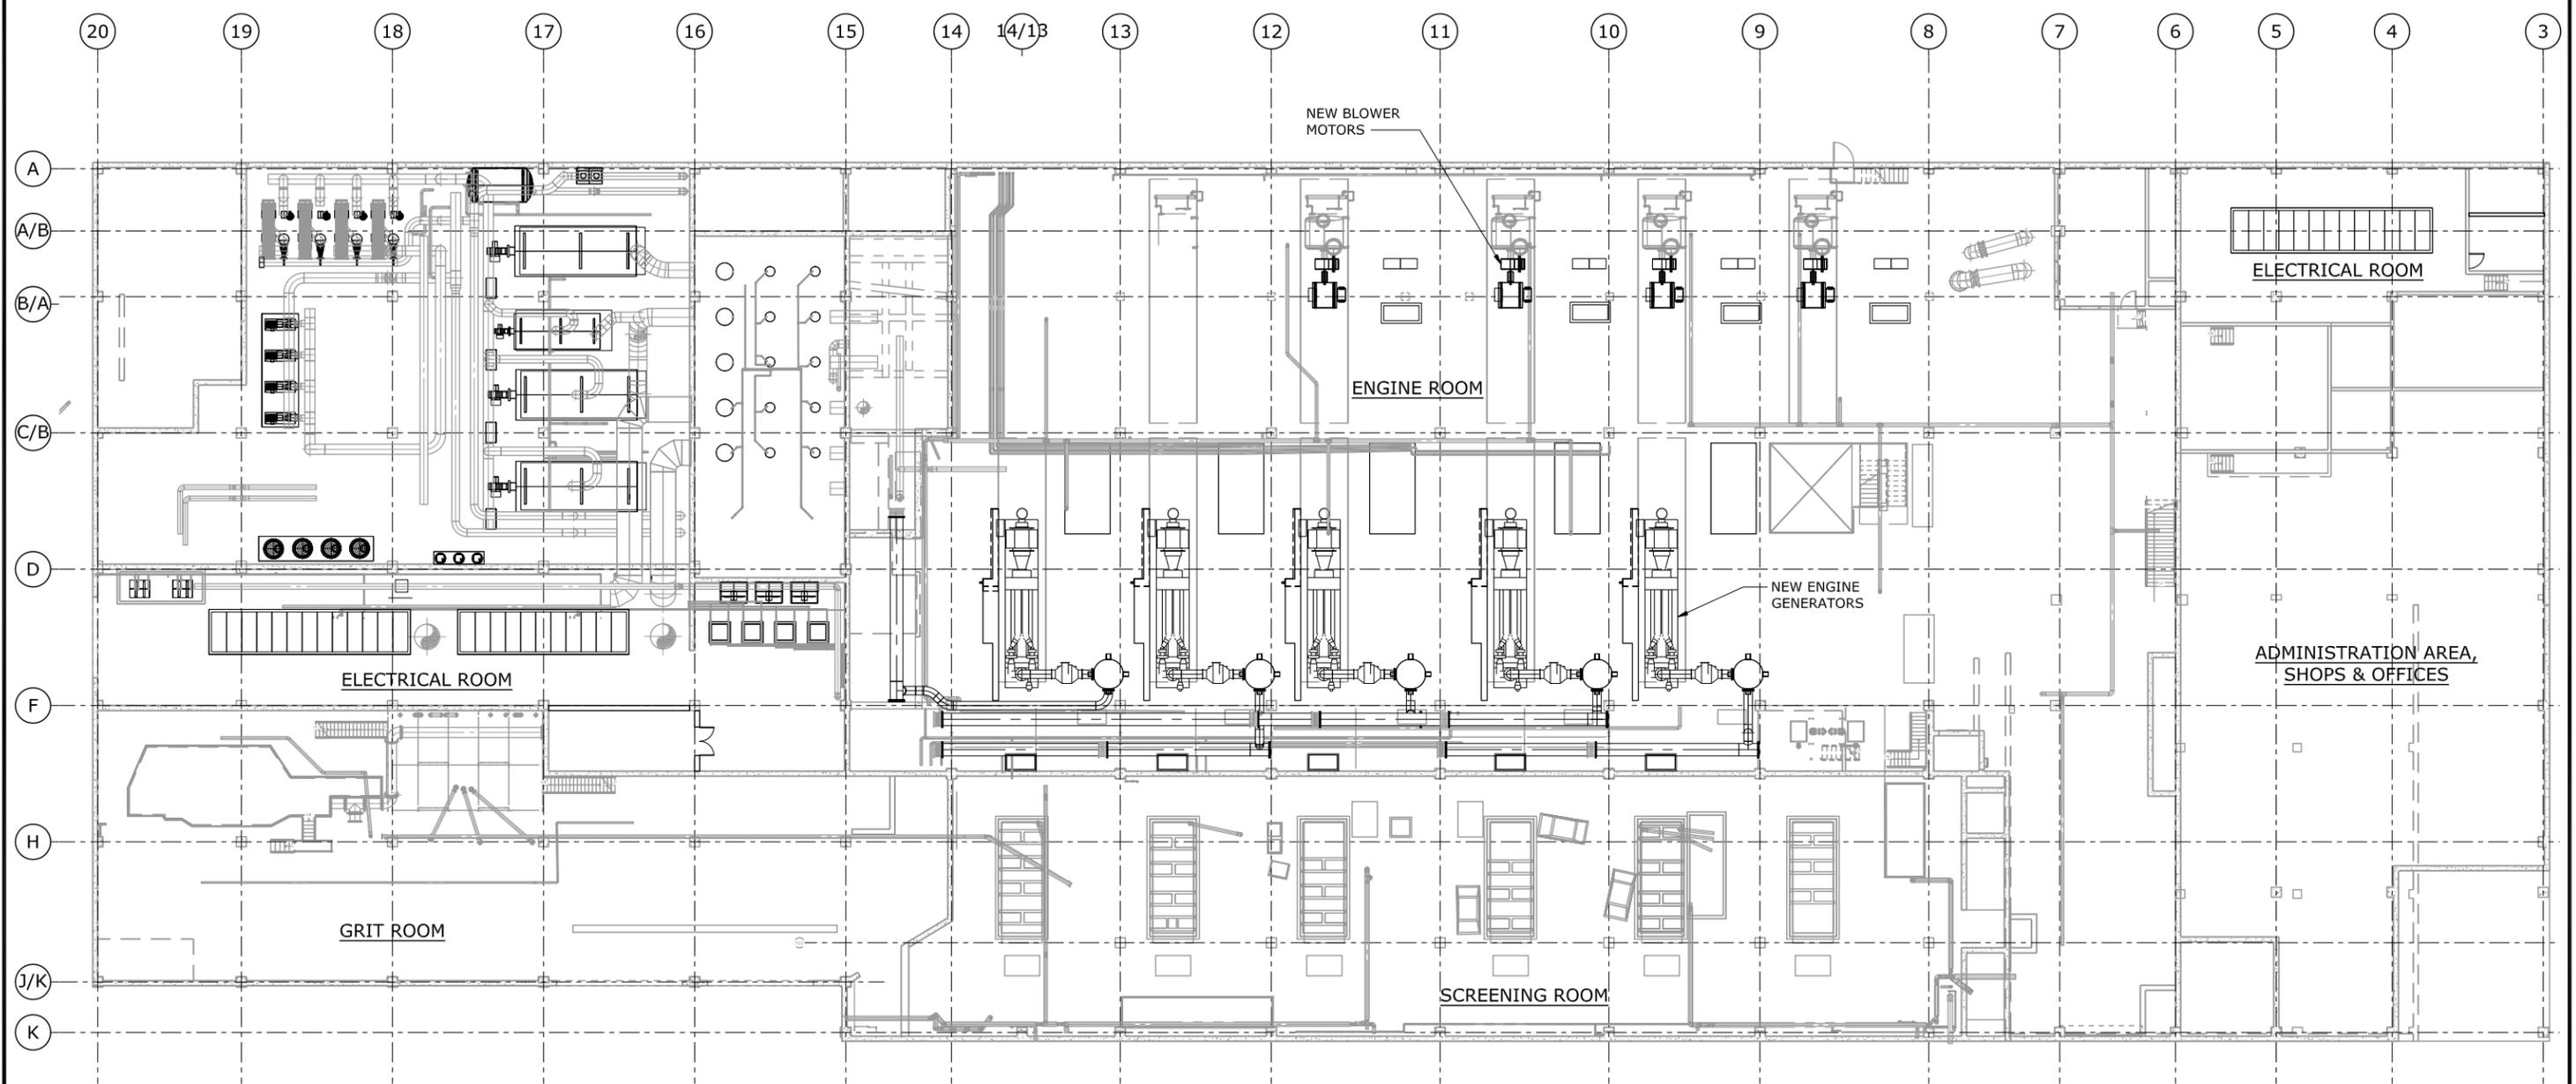

 MAIN BUILDING MECHANICAL PLAN - LEVEL +28.00
 1/16" = 1'-0"



GRAPHIC SCALES
 CHECK BEFORE USE
 IF SHEET IS LESS THAN 22" X 34"
 IT IS A REDUCED PRINT.
 SCALE ACCORDINGLY

FD174911 BORDER
 Last Save By Date and Time: mar17242\3\29\2013 12:17 PM\Plotstyle Table: dep-bedc - 11x17 reduced drawings.ctb
 Date Plotted: 3/29/2013 12:23 PM\Author: mar17242\File Location: c:\users\mar17242\documents_bim+ projects\north river cogen (177129)\mike_j_figures\m21-100.dwg

NO.	DATE	DESCRIPTION	APPR'D.
A	09/12	30% DESIGN SUBMITTAL	
REVISIONS			

DESIGNED BY:
 CHECKED BY:
 DESIGN LEAD:
 SECTION CHIEF:

DRAWN BY:




ACCOUNTABLE MANAGER
 FRANK GIARDINA
 PORTFOLIO MANAGER
 JAMES LAURIA
 ASST. COMMISSIONER
 KEVIN DONNELLY

WARNING—IT IS A VIOLATION, OF THE NEW YORK STATE EDUCATION LAW, SECTION, 7209.2, FOR ANY PERSON, UNLESS (S)HE IS ACTING UNDER THE DIRECTION OF A LICENSED PROFESSIONAL ENGINEER, TO ALTER THIS DOCUMENT IN ANY WAY. IF ALTERED, THE ALTERING PERSON SHALL COMPLY WITH THE REQUIREMENTS OF NEW YORK EDUCATION, LAW, SECTION, 7209.2.


NEW YORK CITY
ENVIRONMENTAL PROTECTION
 BUREAU OF ENGINEERING DESIGN & CONSTRUCTION

NORTH RIVER WWTP
ELECTRIFICATION & COGENERATION
 CONTRACT NR-COGEN

DATE:
 SCALE: 1/16" = 1'-0"
 SHEET NO. OF
 DRAWING NO.
 M21-100

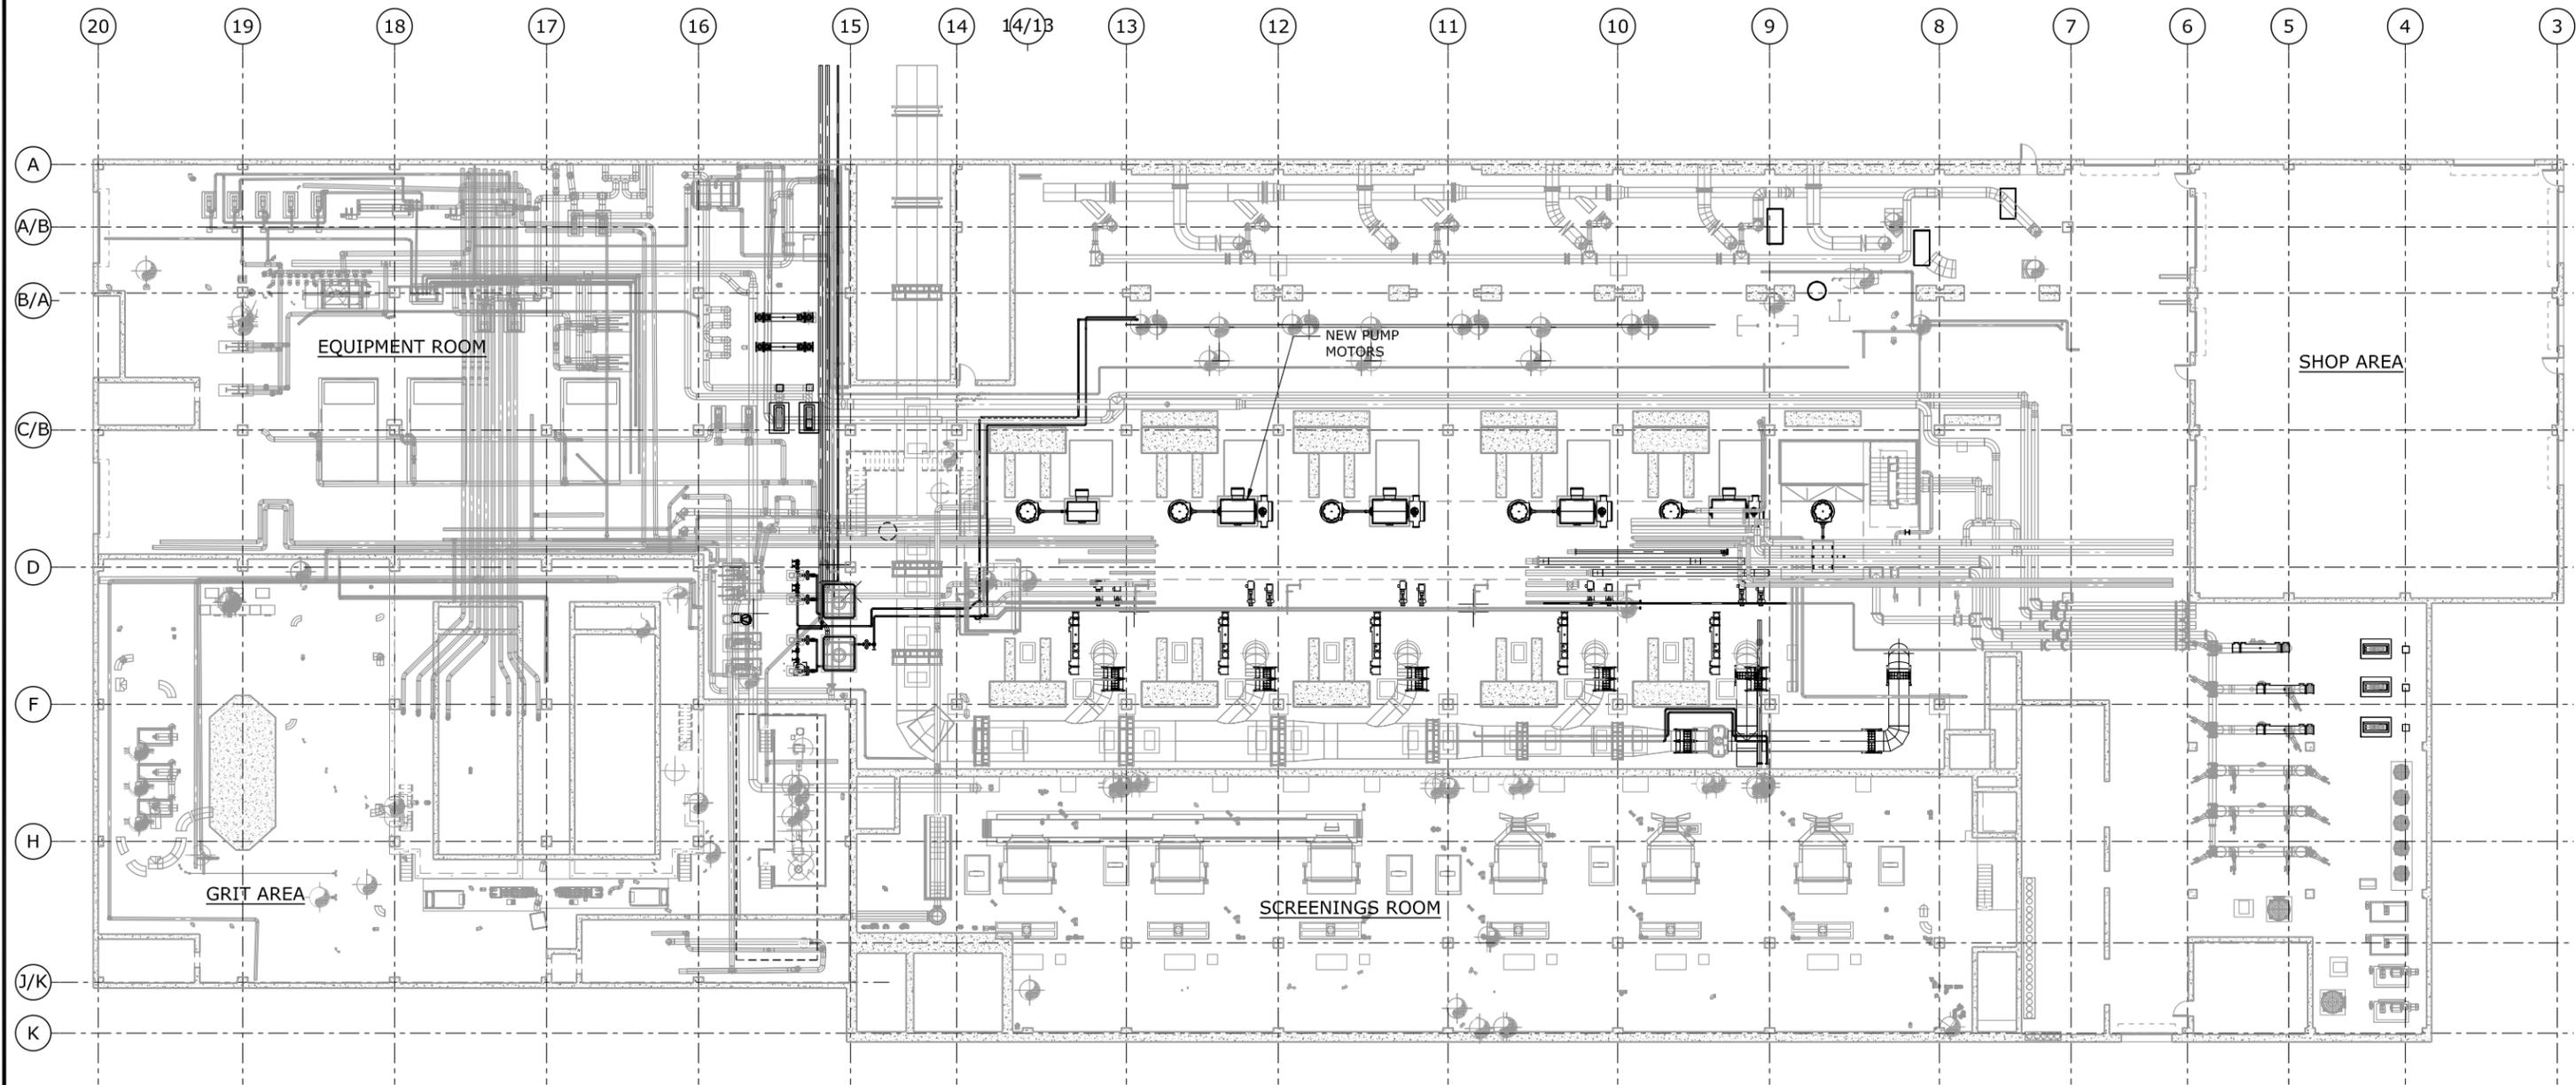

 MAIN BUILDING MECHANICAL PLAN - LEVEL +5.00
 1/16" = 1'-0"



GRAPHIC SCALES
 CHECK BEFORE USE
 IF SHEET IS LESS THAN 22" X 34"
 IT IS A REDUCED PRINT.
 SCALE ACCORDINGLY

FD174911 BORDER
 Last Save By Date and Time: mar17242\3/29/2013 1:37 PM\Plotstyle Table: dep-bedc - 11x17 reduced drawings.ctb
 Date Plotted: 3/29/2013 2:06 PM\Author: mar17242\File Location: c:\users\mar17242\documents_bim+ projects\north river cogen (177129)\mike.j.figures\m22-100.dwg

NO.	DATE	DESCRIPTION	APPR'D.
A	09/12	30% DESIGN SUBMITTAL	
REVISIONS			

DESIGNED BY:
MSJ,DWW

CHECKED BY:

DESIGN LEAD:

SECTION CHIEF:

DRAWN BY:
JMM



BLACK & VEATCH
 Building a world of difference

Black & Veatch New York, LLP
 480 Park Avenue New York, NY 10022



ACCOUNTABLE MANAGER
FRANK GIARDINA

PORTFOLIO MANAGER
JAMES LAURIA

ASST. COMMISSIONER
KEVIN DONNELLY

WARNING—IT IS A VIOLATION, OF THE NEW YORK STATE EDUCATION LAW, SECTION, 7209.2, FOR ANY PERSON, UNLESS (S)HE IS ACTING UNDER THE DIRECTION OF A LICENSED PROFESSIONAL ENGINEER, TO ALTER THIS DOCUMENT IN ANY WAY. IF ALTERED, THE ALTERING PERSON SHALL COMPLY WITH THE REQUIREMENTS OF NEW YORK EDUCATION, LAW, SECTION, 7209.2.

NEW YORK CITY
ENVIRONMENTAL PROTECTION
 BUREAU OF ENGINEERING DESIGN & CONSTRUCTION

NORTH RIVER WWTP
ELECTRIFICATION & COGENERATION
 CONTRACT NR-COGEN

DATE: 08/31/12
 SCALE: 1/16" = 1'-0"
 SHEET NO:
 OF
 DRAWING NO.
M22-100